


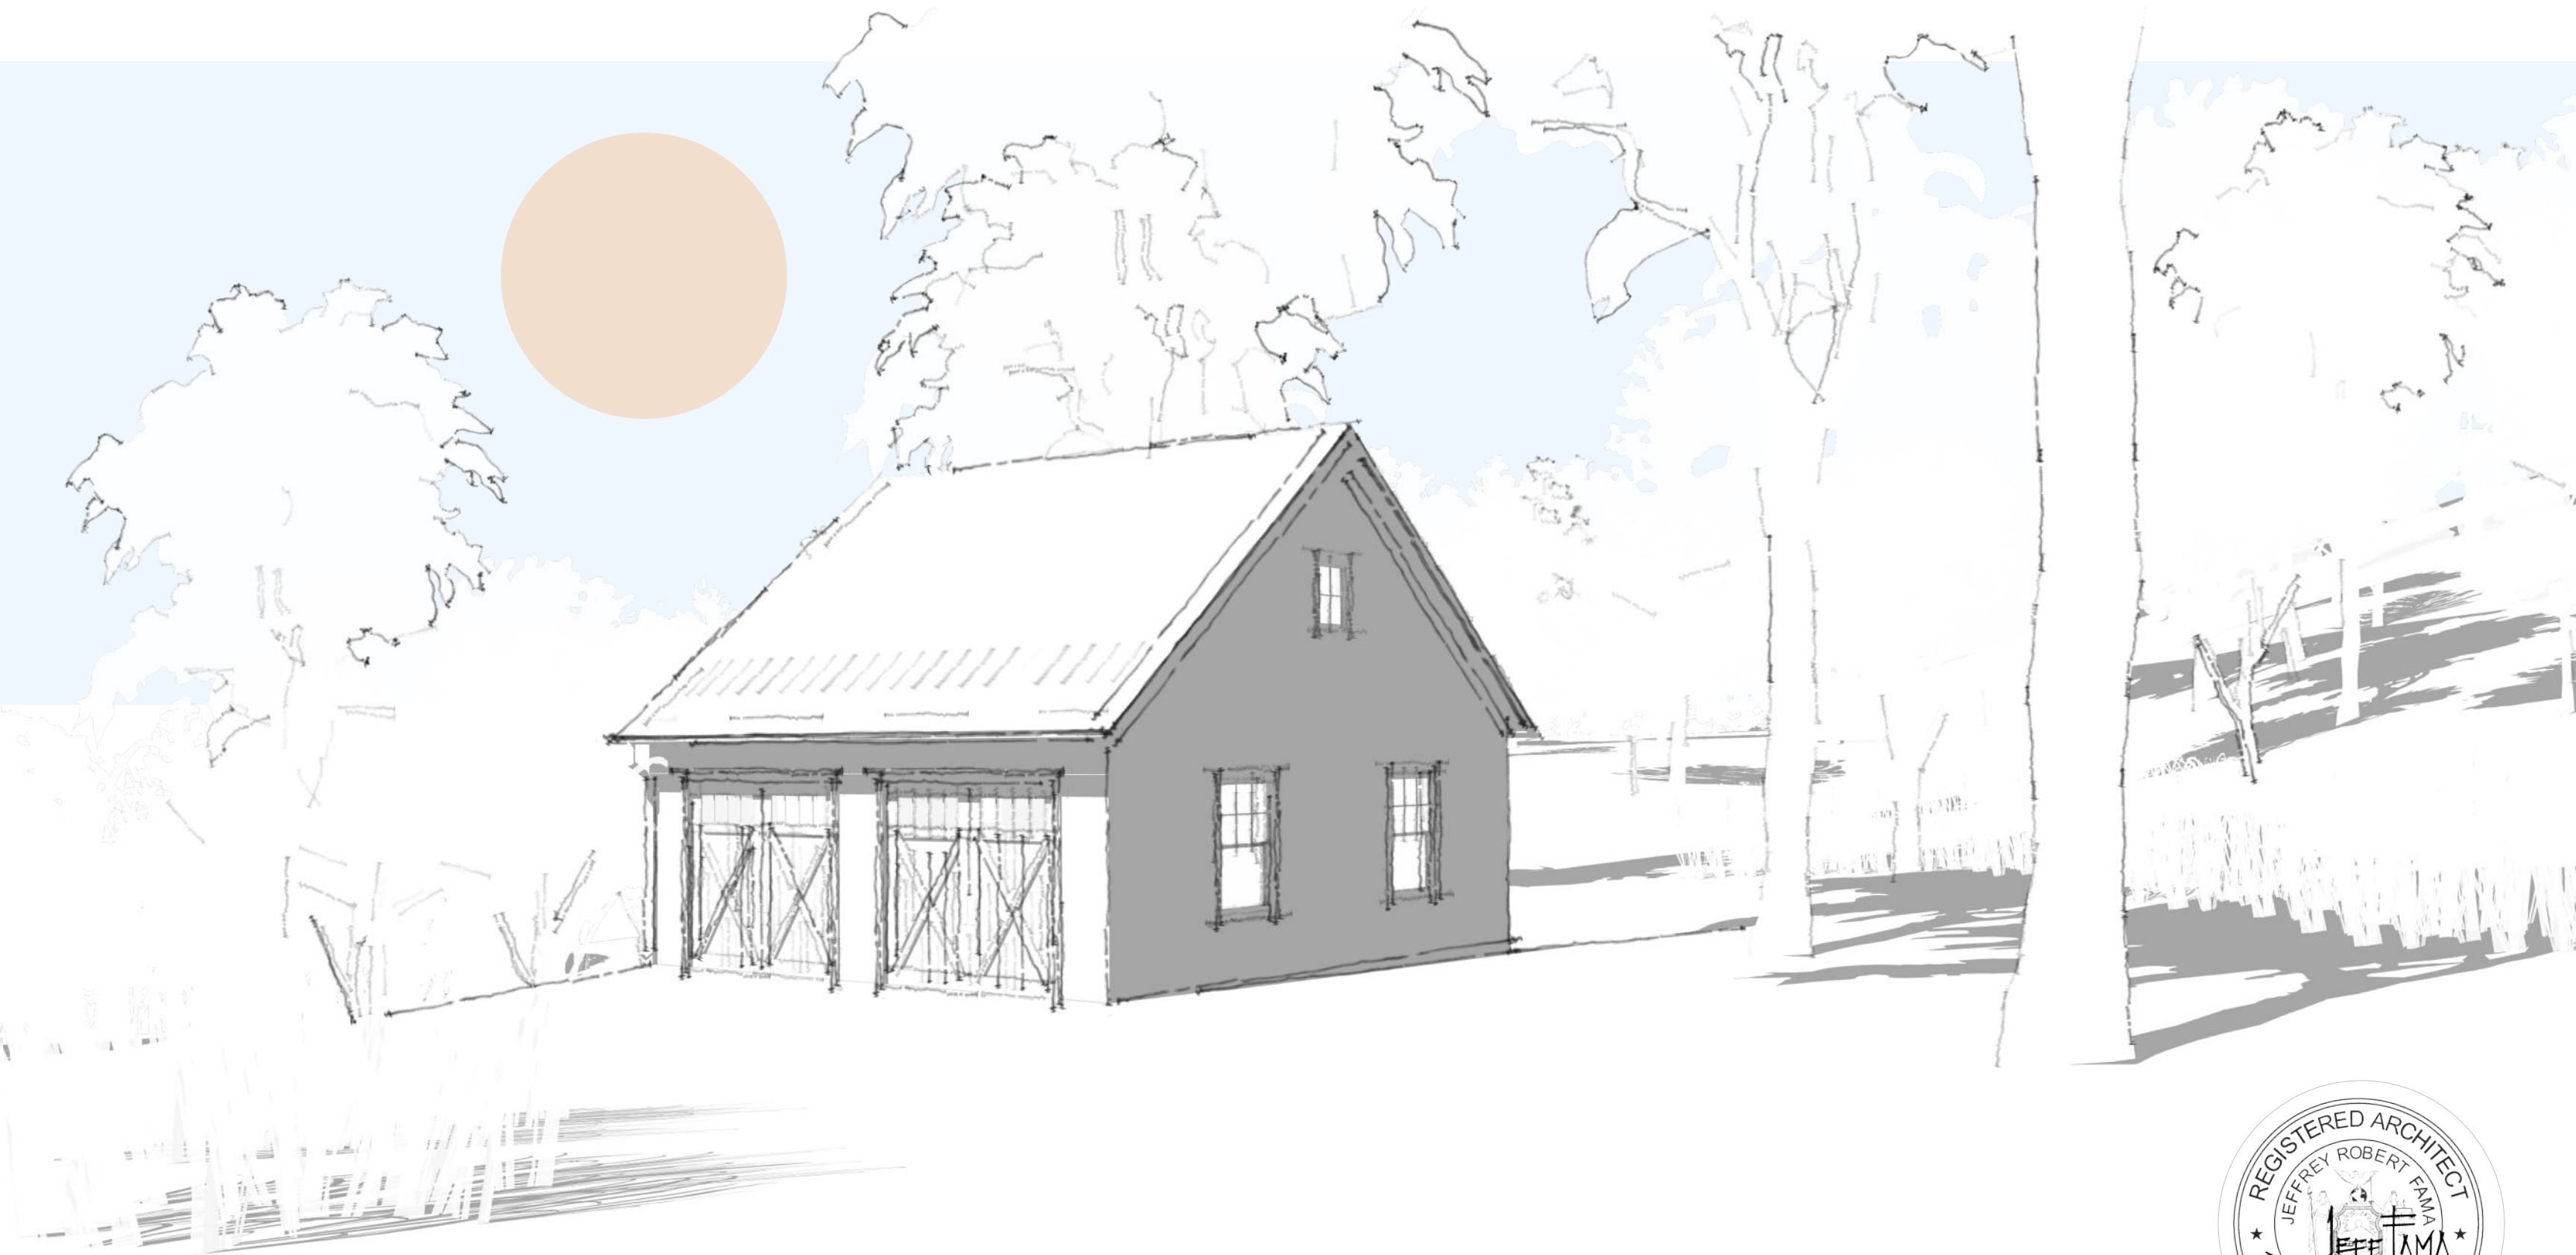

SHEET NO:

BAR 1.0

ISSUE DATE:

08.03.26

SHEET TITLE:

BAR REVIEW SUPLIMENTAL PACKAGE

DRAWING SCALE:

NOT TO SCALE

PROJECT NAME

178 CONTINENTAL ROAD GARAGE

PROJECT NUMBER:

2604



BLACK HAUSE STUDIO



EXISTING GARAGE - VIEW FROM DRIVEWAY



EXISTING GARAGE - WEST ELEVATION



EXISTING GARAGE - LOOKING NORTH FROM CONTINENTAL ROAD



EXISTING GARAGE - NORTH ELEVATION







EXISTING GARAGE - SOUTH ELEVATION



EXISTING GARAGE - LOOKING SOUTHWEST FROM CONTINENTAL ROAD




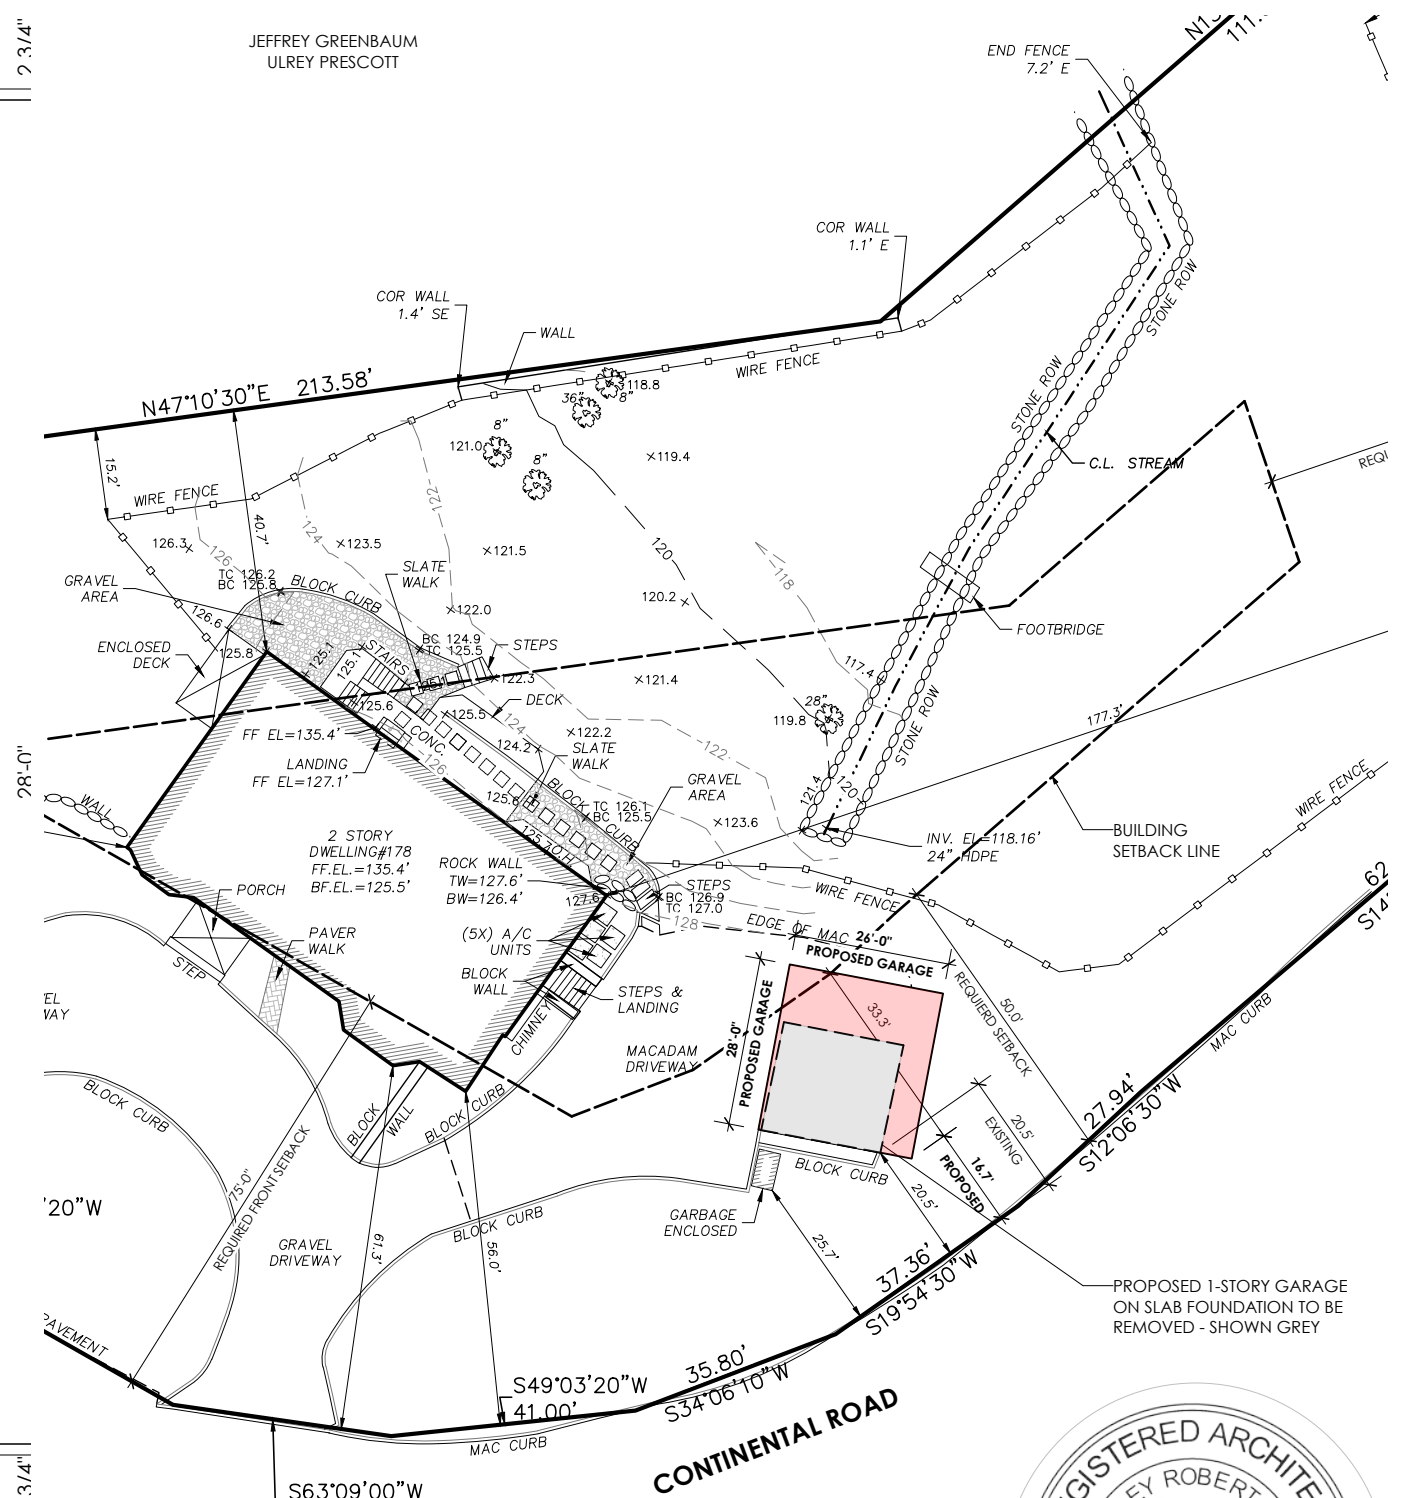

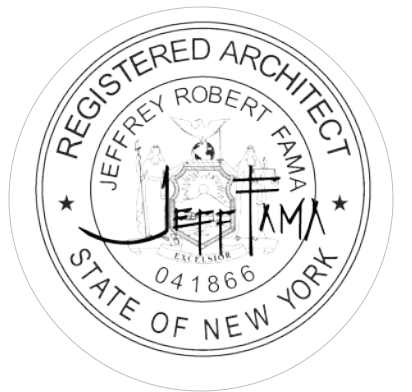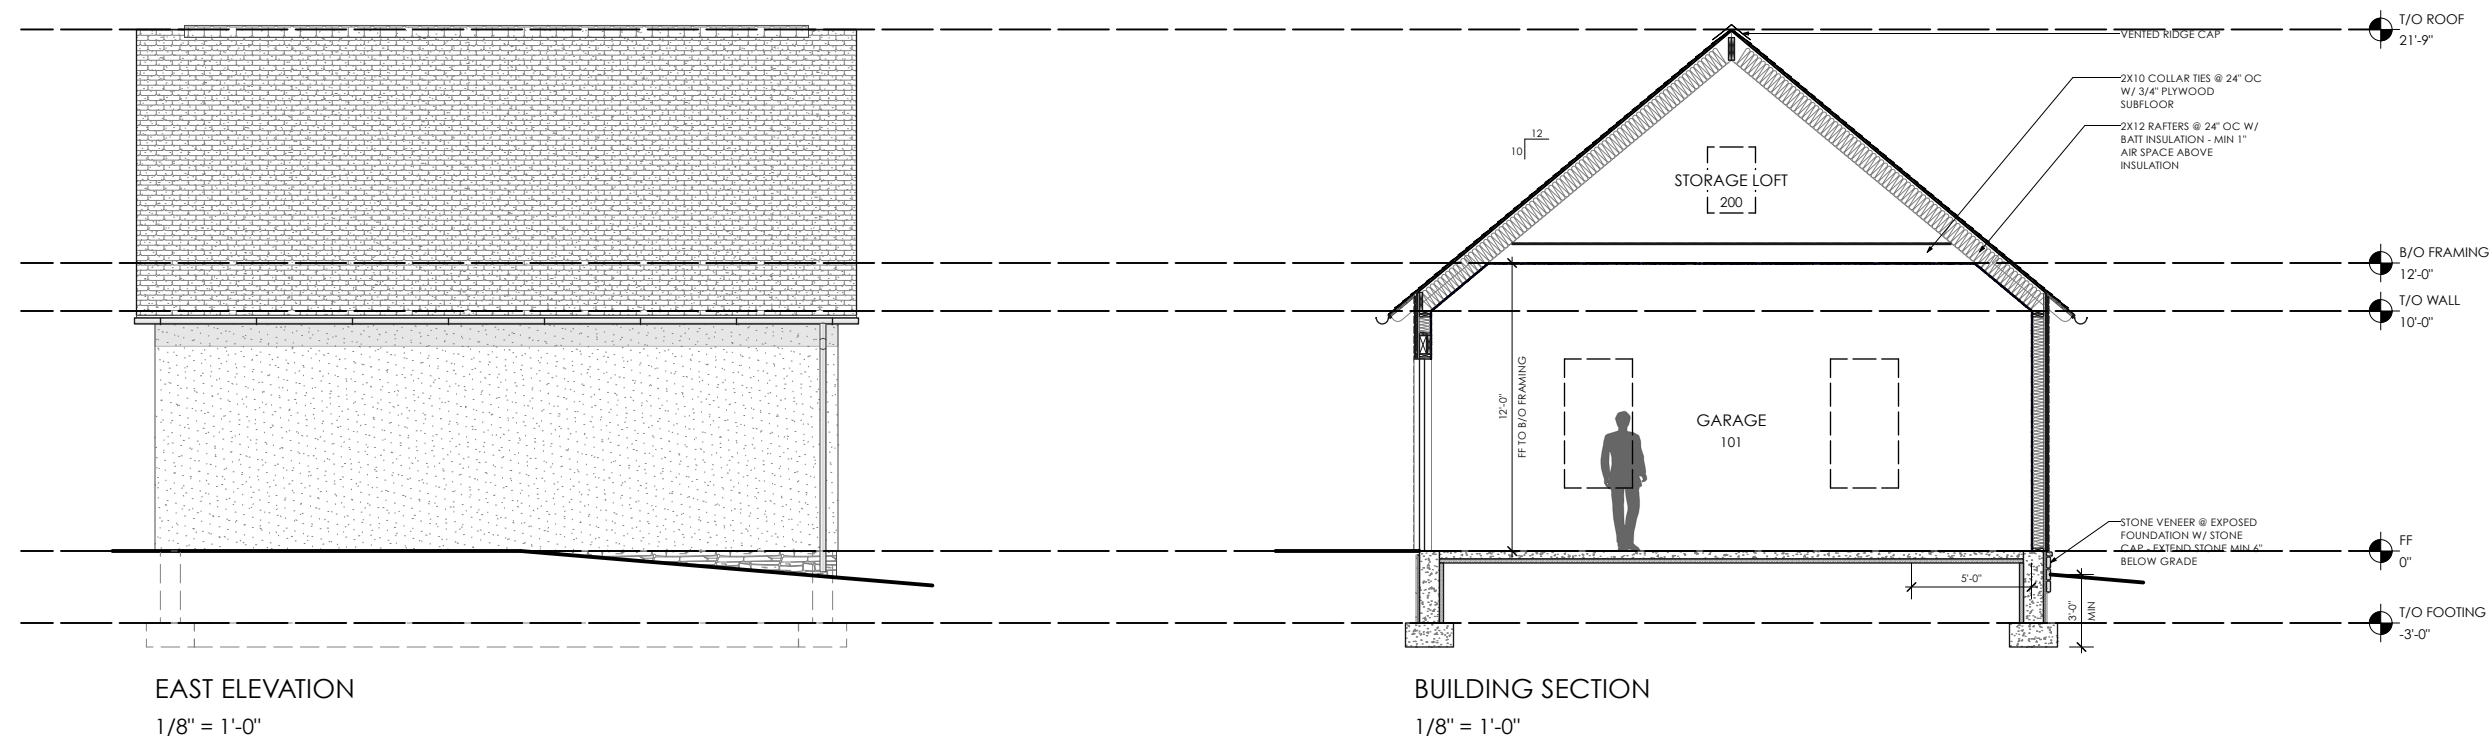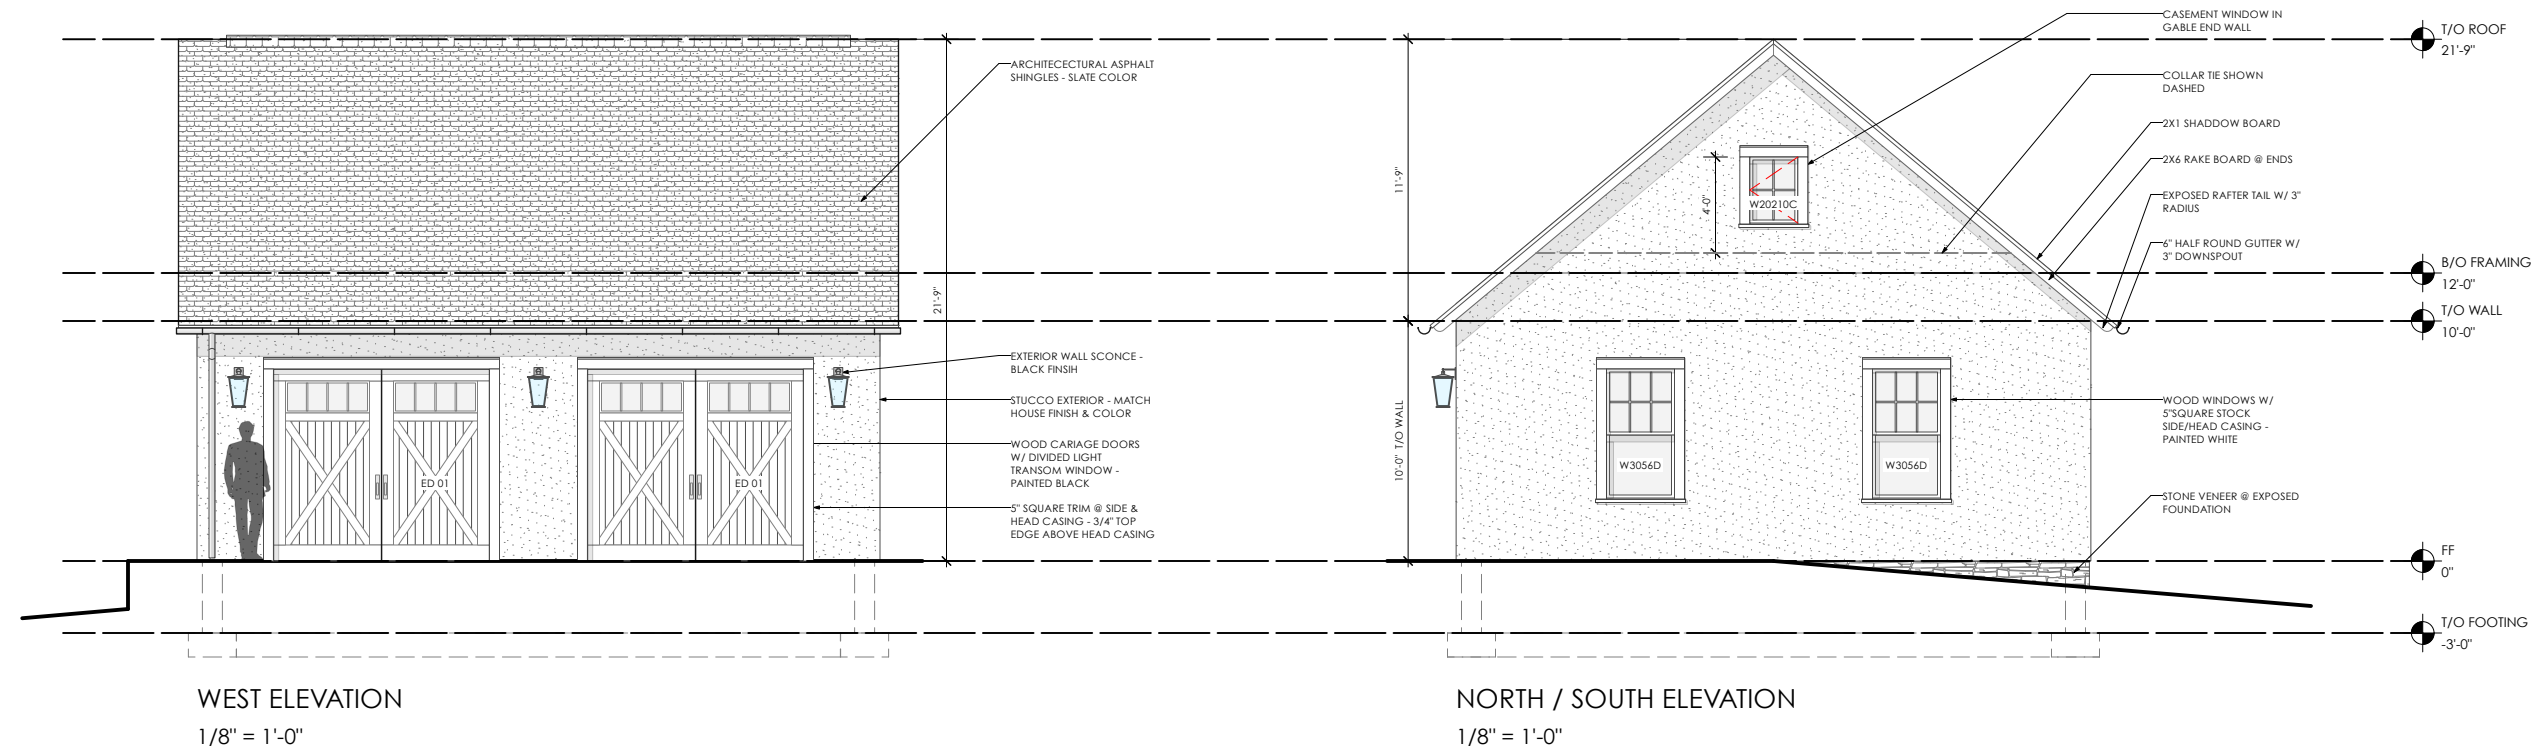



 
ROOF: ASPHALT SHINGLE SLATE COLOR
(MATCH EXISTING HOUSE)



WINDOW EXTERIOR: JELD WEN BONE WHITE




STUCCO FINISH TO MATCH EXISTING HOUSE

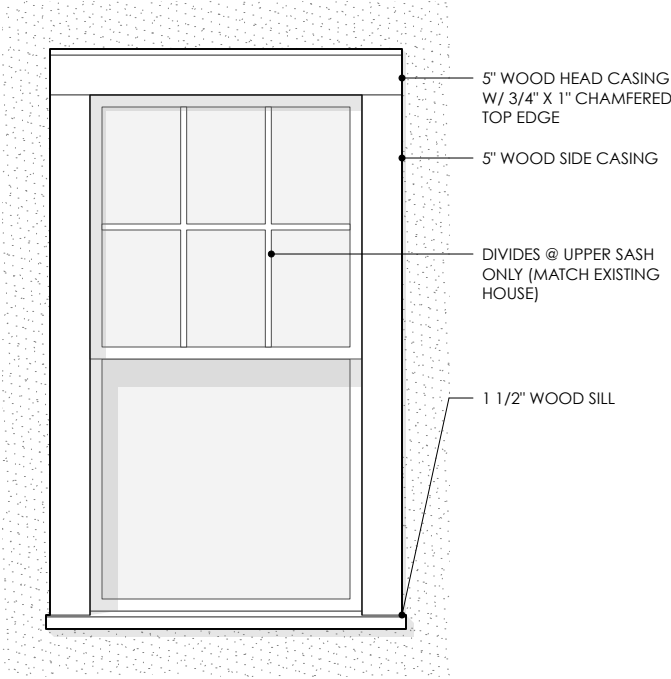

WINDOW NOTES:
EXTERIOR WINDOWS TO BE JELD WEN ALL
WOOD WINDOWS




PROPOISED EXTERIOR WALL SCONCE
DARK SKY COMPLIENT

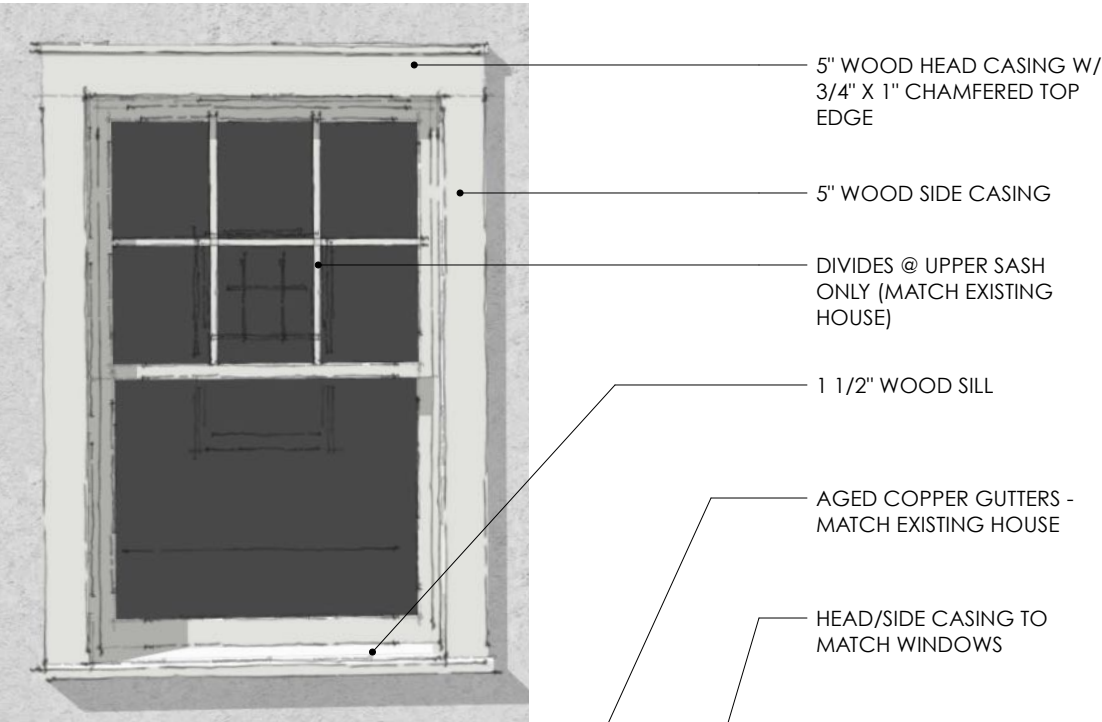

CARIAGE DOORS
ALL WOOD CROSS BRACE DESIGN WITH TRANSOM WINDOW
PAINTED BLACK TO MATCH FRONT DOOR OF HOUSE



EXISTING FRONT DOOR
FOR COLOR REFERENCE

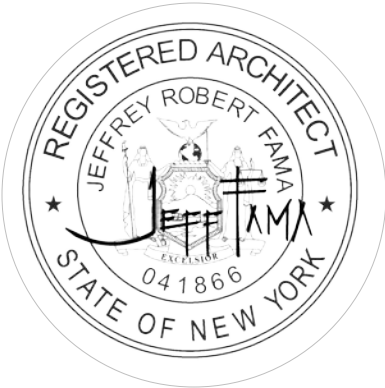



PERSPECTIVE FROM DRIVEWAY



PERSPECTIVE @ FRONT



PERSPECTIVE @ FRONT CORNER



PERSPECTIVE FROM REAR CORNER



SOREN

TROY LIGHTING

B8907-TBK

This timeless silhouette, which is made from an exclusive EPM material and is part of the Troy Elements collection, can withstand a multitude of outdoor elements, including UV and salt exposure for years to come in style. The Soren family offers a sleek yet familiar silhouette in wall sconce, lantern, and post configurations.

*SKUs B8905-TBK, B8906-TBK, B8907-TBK, and B8908-TBK are Dark Sky Compliant and feature integrated LED

FINISHES

TE

TEXTURE BLACK
Coastal Suitable Finish (EPM): Yes

DIMENSIONS / SPECS

Height: 23"
Width/Diameter: 11"
Canopy/Backplate: 6"
Product Weight: 7.98lb
Extension: 12.25"
Top to Center: 4.25"
Canopy/Backplate Shape: Rectangle
Sloped Ceiling Compatible: No
Living Finish: No
Uplight Only: Yes

Shade 1: Glass
Shade 1 Finish: Clear Seeded
Shade 1 Top Width: 9.5"
Shade 1 Bottom L/W: 0" / 7.25"
Shade 1 Height: 15"

ELECTRICAL

ifit

UL LISTED

Bulb 1
Bulb Included: N/A
Socket: Integrated LED
Max Wattage: 9
Bulb Quantity: 1
Wire Length: 7"
Cord Type: B & W TEFLON W/ COPPER
GROUND WIRE

Dimmer Type: TRIAC Dimmable
Gem Box Required (2"x3"): No
Dark Sky: Yes
Convertible: No

CRI: 90
Color Temp.: 2700k
Lumens: 275
Title 24: No
Field Serviceable: Yes
Voltage: 120V

Voltage:
UL Rating: cETL Wet
Gem Box: Not Required

SHIPPING

Carton 1: 28" x 15" x 17"
Carton 1 Weight: 12lb
Shipping Method: Ground
Country of Origin: TH



HUDSON VALLEY
LIGHTING GROUP

DARK SKY COMPLIANT

YES - FIXTURE LISTED ON DARKSKY.ORG

LAMP COLOR TEMP

2700 K

LUMENS

275



BLACK HAUSE STUDIO